
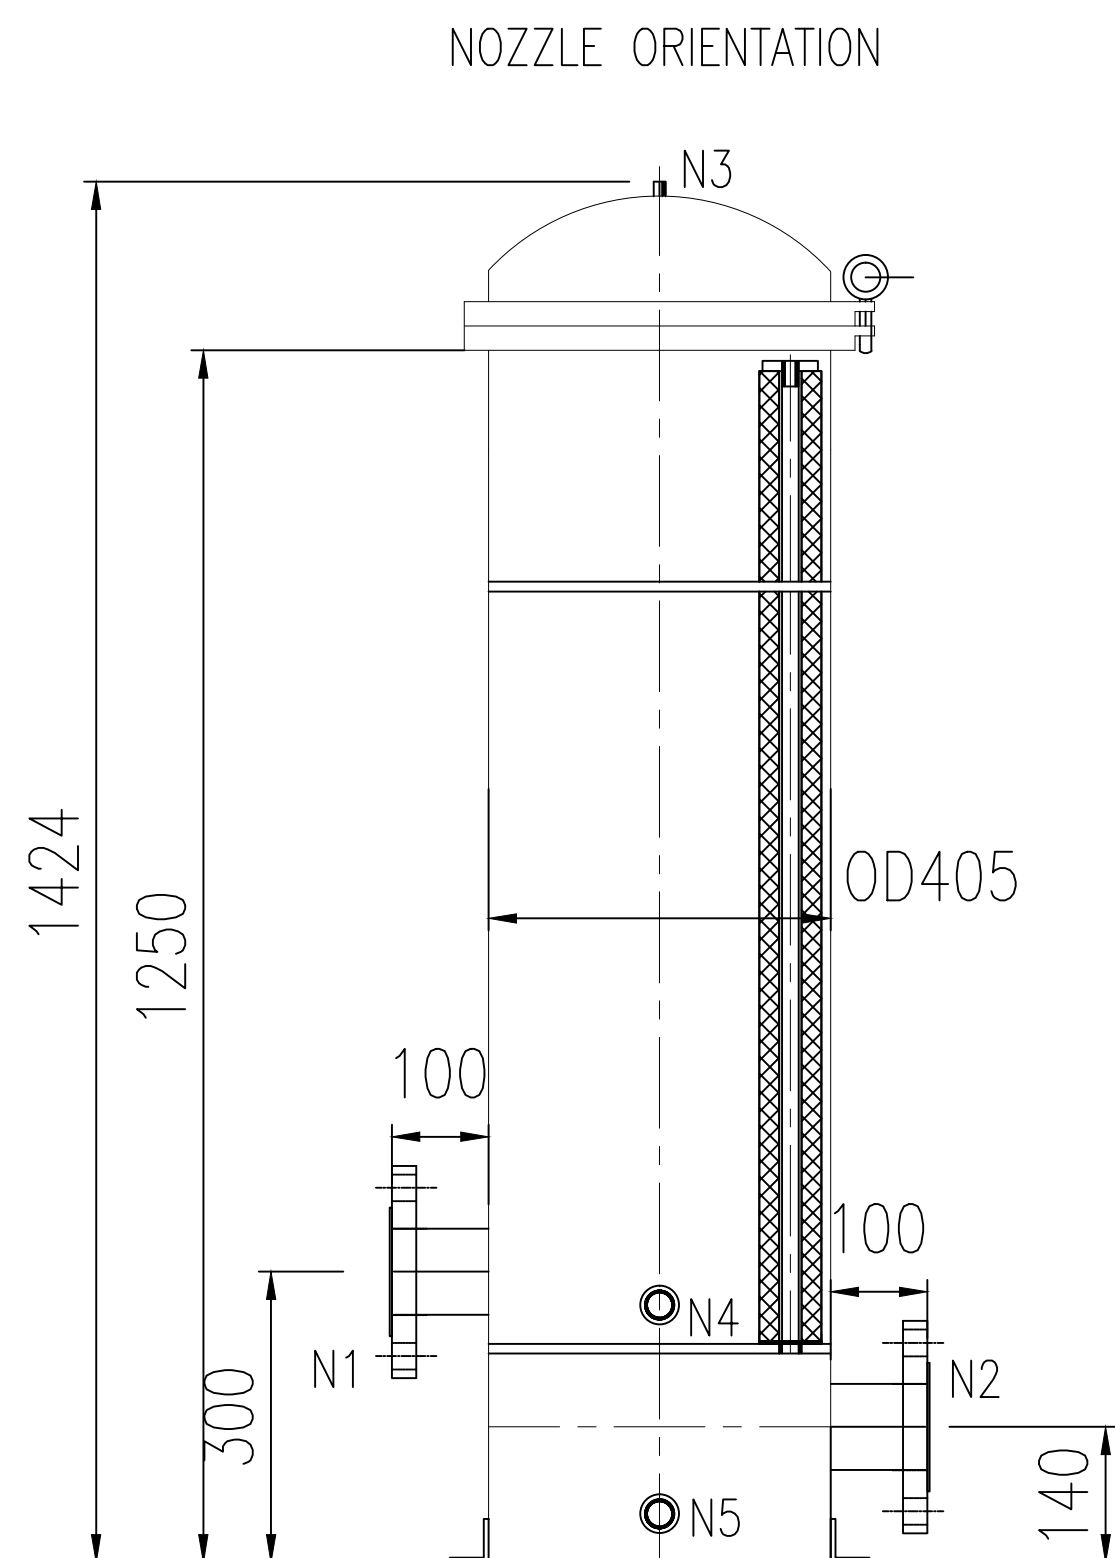


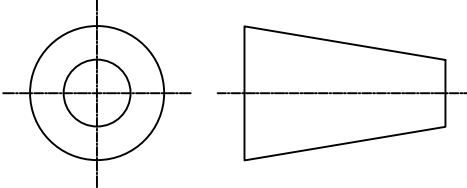

NOTE:
ALL DIMENSIONS ARE IN MM
ACCESSORIES DRAIN VALVE, VENT VALVE, PRESSURE GAUGE ARE OPTIONAL

 IQ WATER Your Satisfaction Our Success		DRAWN	KUMAR
		CHKD	SATHISH
		APPD	LAKSHMAM
		DATE	07.07.2020
		SCALE	NTS
		Ph No:	9789714220,8072031030
No:16-A, 3rd Street , Sakthi Nagar, Kolathur, Chennai - 600099			
CLIENT :			
PROJECT :	WTP PLANT – 40m ³ /hr		
TITLE :	SKID GA DIAGRAM		
DRG NO :	A3/IQ/PRO161/WTP/P&ID-001		
		SHEET : 1 OF 1	
		REV : '02'	